


FIRST FLOOR PLAN ①

SCALE: 1/4" = 1'-0"

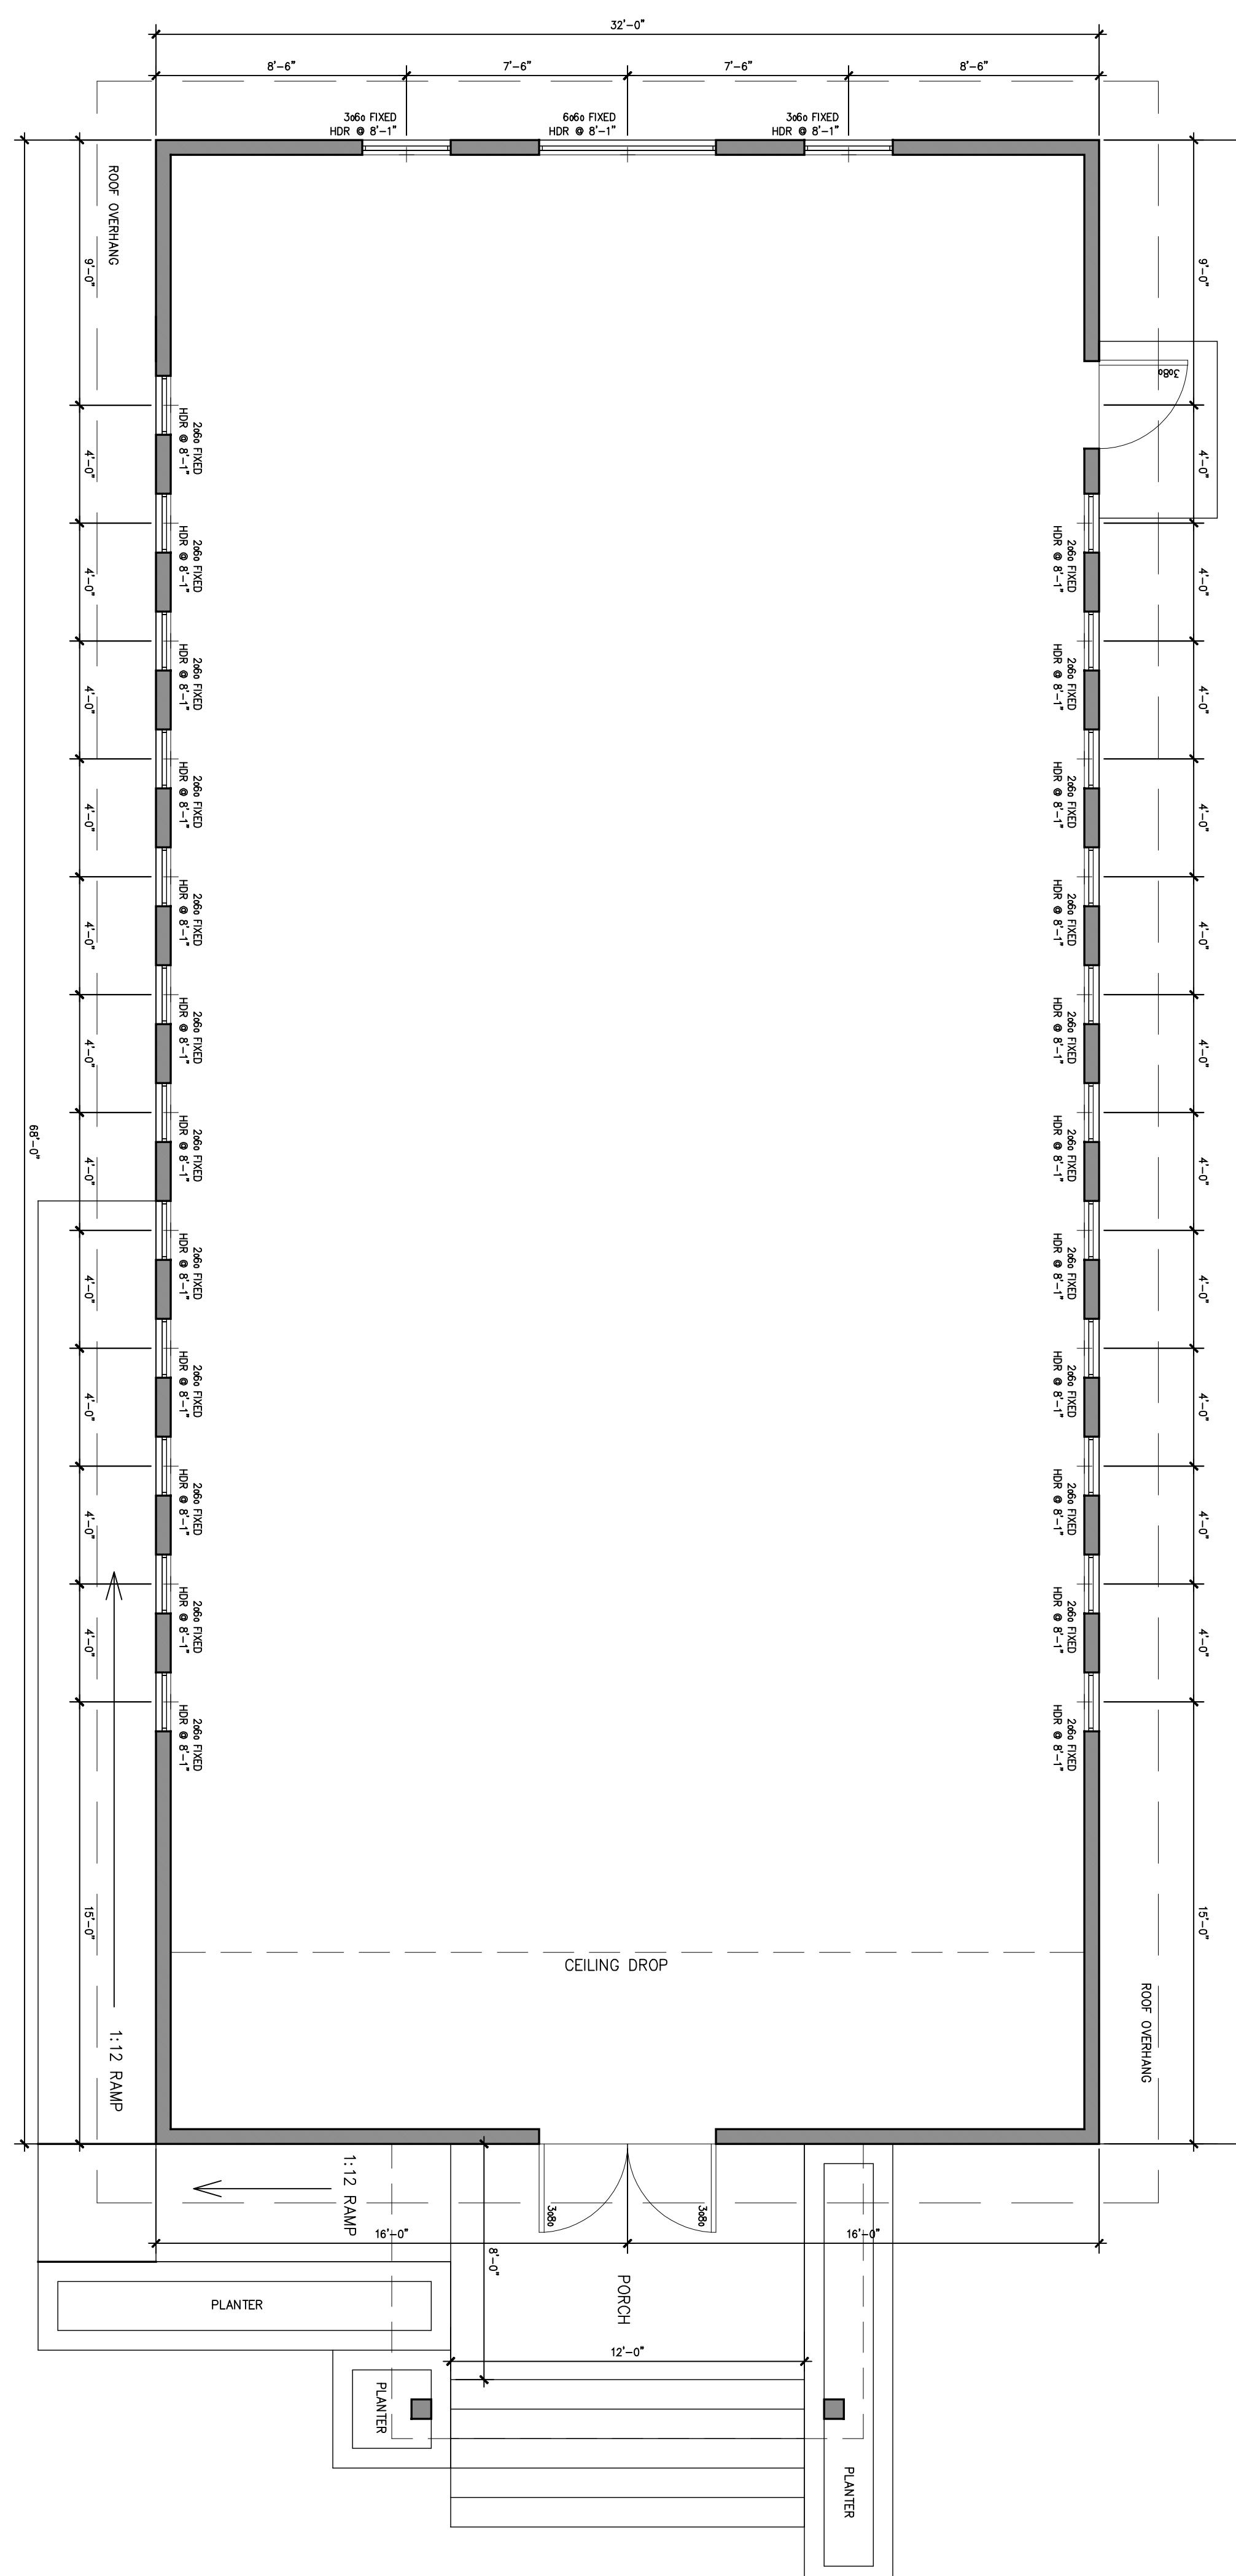

* FIRE SPRINKLER
DESIGN BY OTHERS



Albany Studio

2802 Albany St.
Houston, TX 77006
936.419.6474
www.albanystudio.com

UNCLE TERRY
9282 COUNTY RD.

FIRST FLOOR PLAN
Nov 30 2019

A2.1